


THIS PLAN REPRESENTS A CONCEPTUAL DESIGN FOR STORRS CENTER. STREET CONFIGURATIONS, DIMENSIONS AND BUILDING SHAPES AND LOCATIONS ARE PRELIMINARY AND SUBJECT TO CHANGE. THE CONCEPTUAL PLAN IS PROVIDED IN ORDER TO DESCRIBE THE INTENDED NATURE AND CHARACTER OF THE PROJECT.

KEY:

- W — EXISTING WATER MAIN
- W — PROPOSED WATER MAIN
- S — EXISTING SANITARY SEWER
- S — PROPOSED SANITARY SEWER

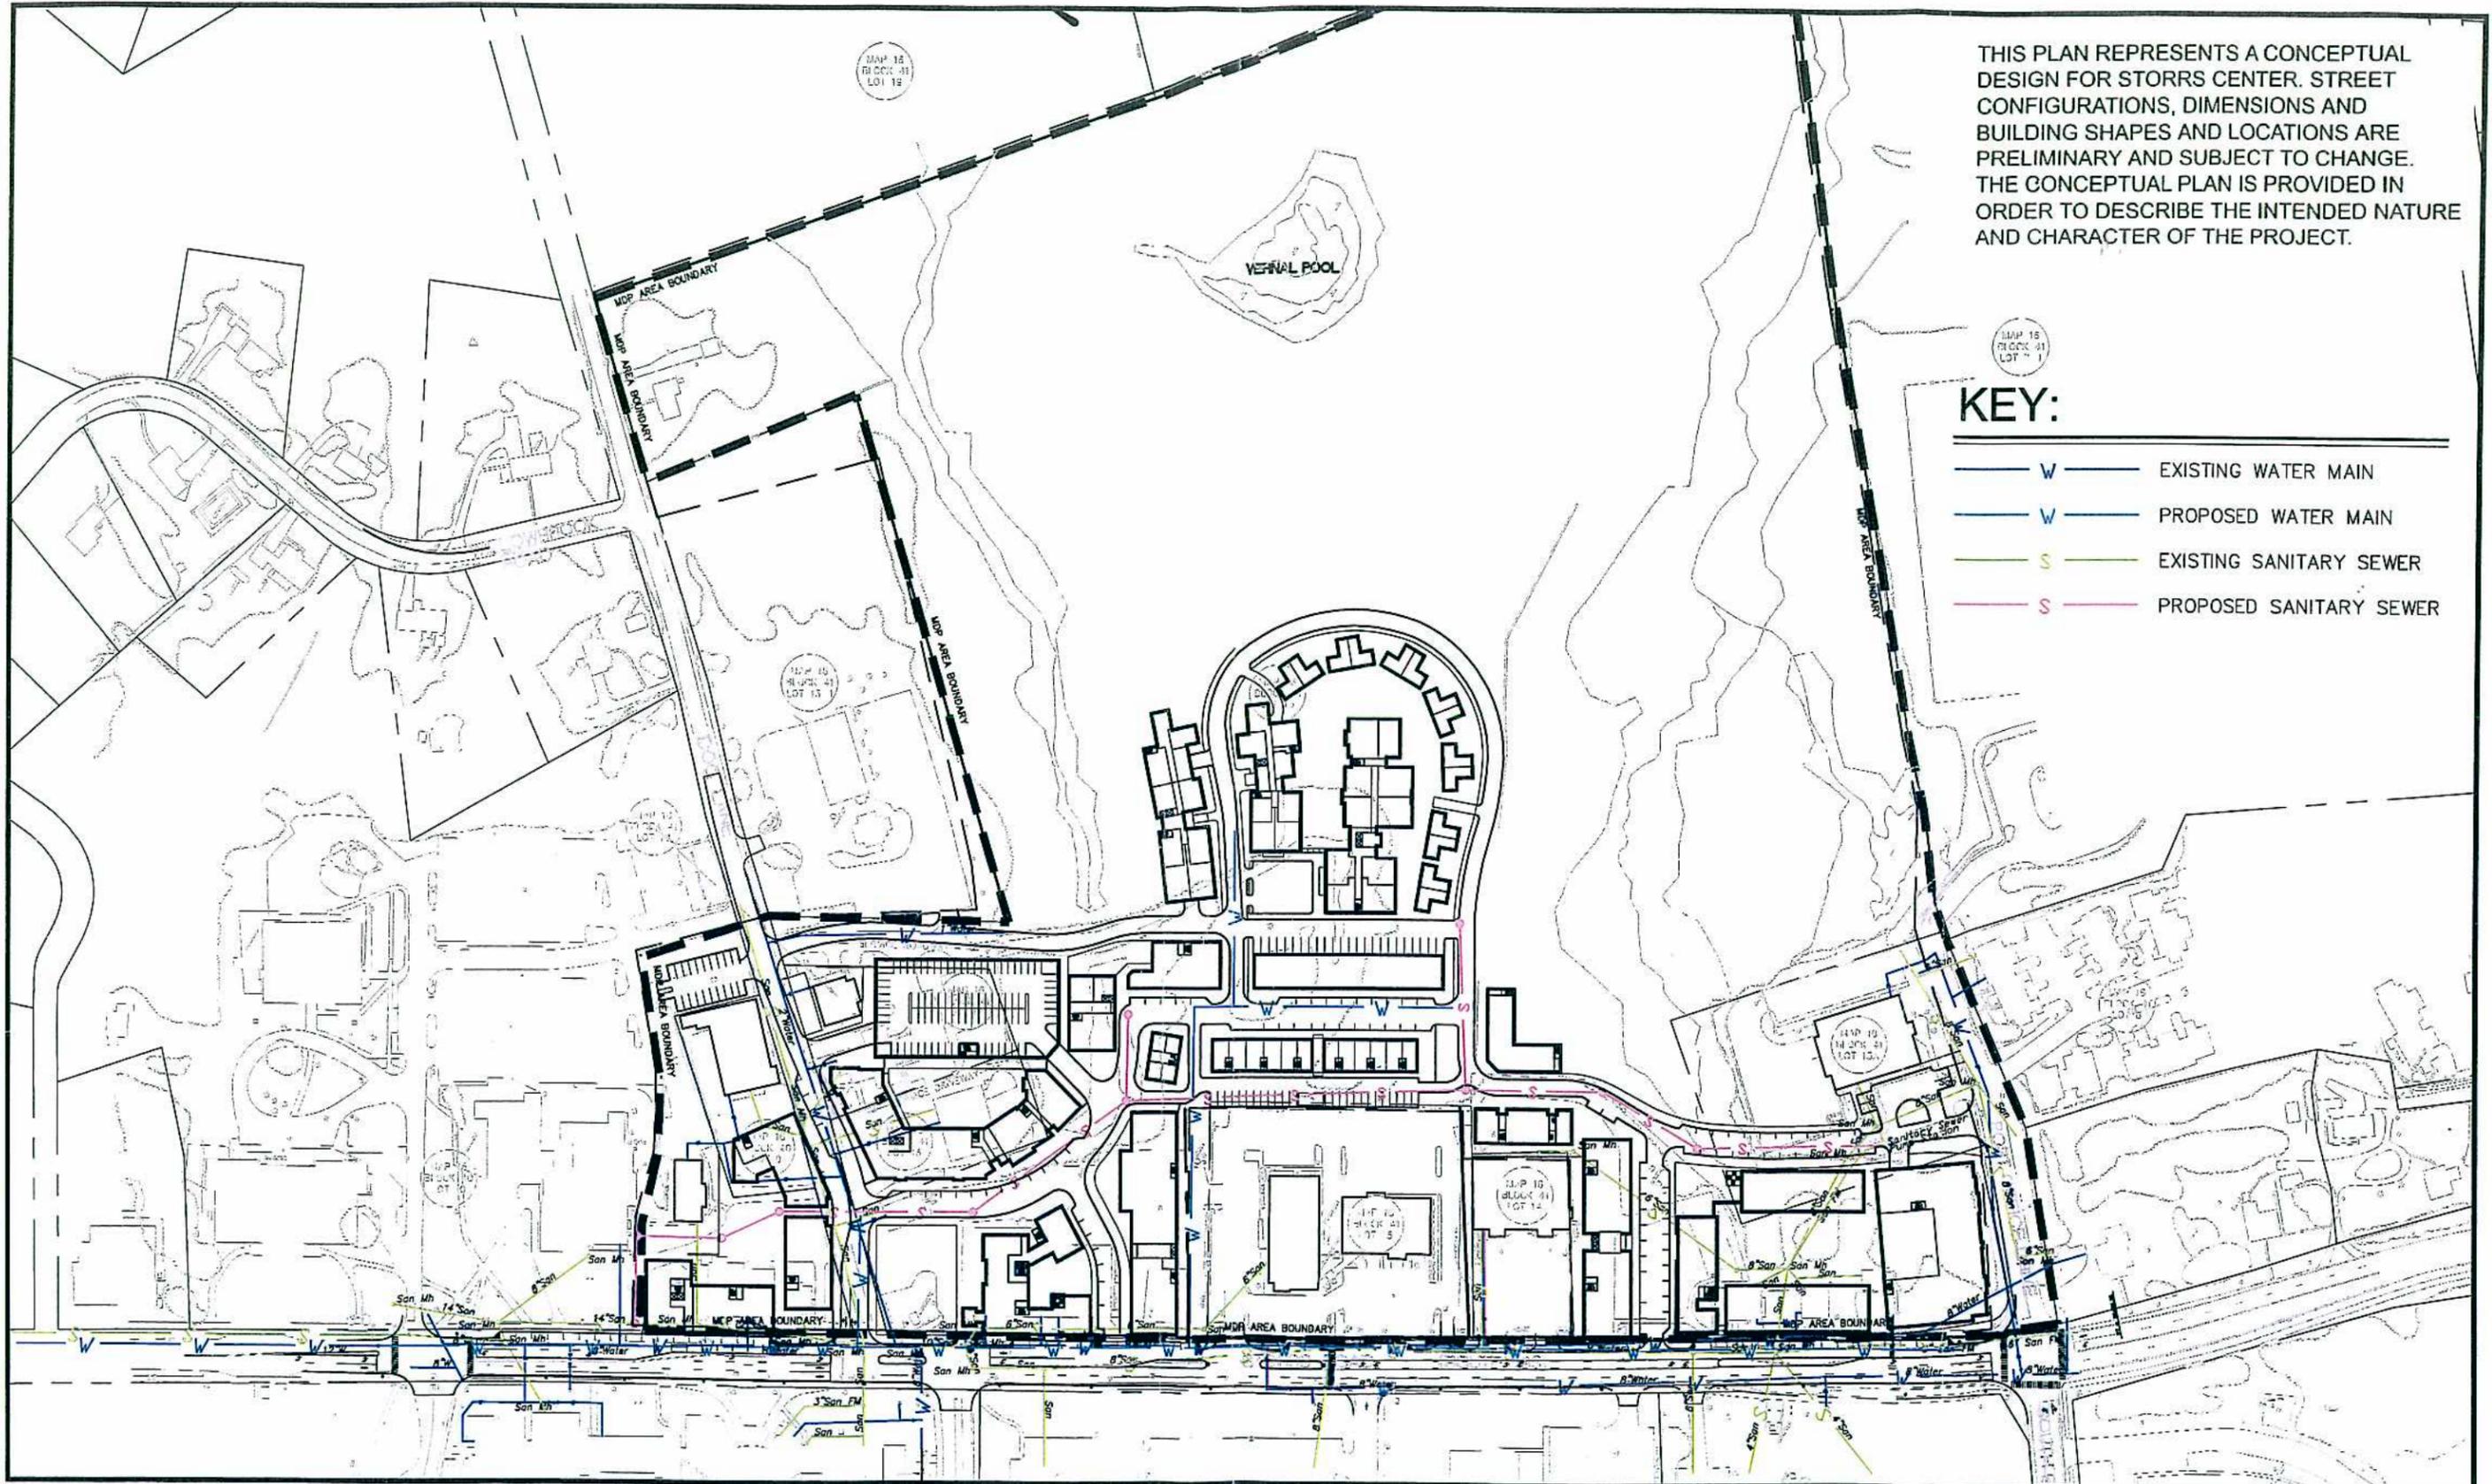

ARCHITECTURE
ENGINEERING
PLANNING
LANDSCAPE ARCHITECTURE
LAND SURVEYING
ENVIRONMENTAL SCIENCES

355 Research Parkway
Meriden, CT 06450
(203) 630-1406
(203) 630-2615 Fax

PROPOSED UTILITY PLAN - SANITARY AND WATER SERVICE

STORRS CENTER
MUNICIPAL DEVELOPMENT PLAN
MANSFIELD, CONNECTICUT

Designed	P.M.B.
Drawn	P.M.B.
Checked	
Approved	
Scale	1"=200'
Project No.	03C667
Date	4/07/05
CAD File	PU03C66703

PU-3

FIGURE 14

XREF(s): XYC66701, XYC66702